


THE HASHEMITE KINGDOM OF JORDAN PDTRA PETRA DEVELOPMENT TOURISM REGION AUTHORITY



PETRA CULTURAL HERITAGE VILLAGE BUILDINGS PART III

DRAFT FINAL DRAWINGS MAY - 2015

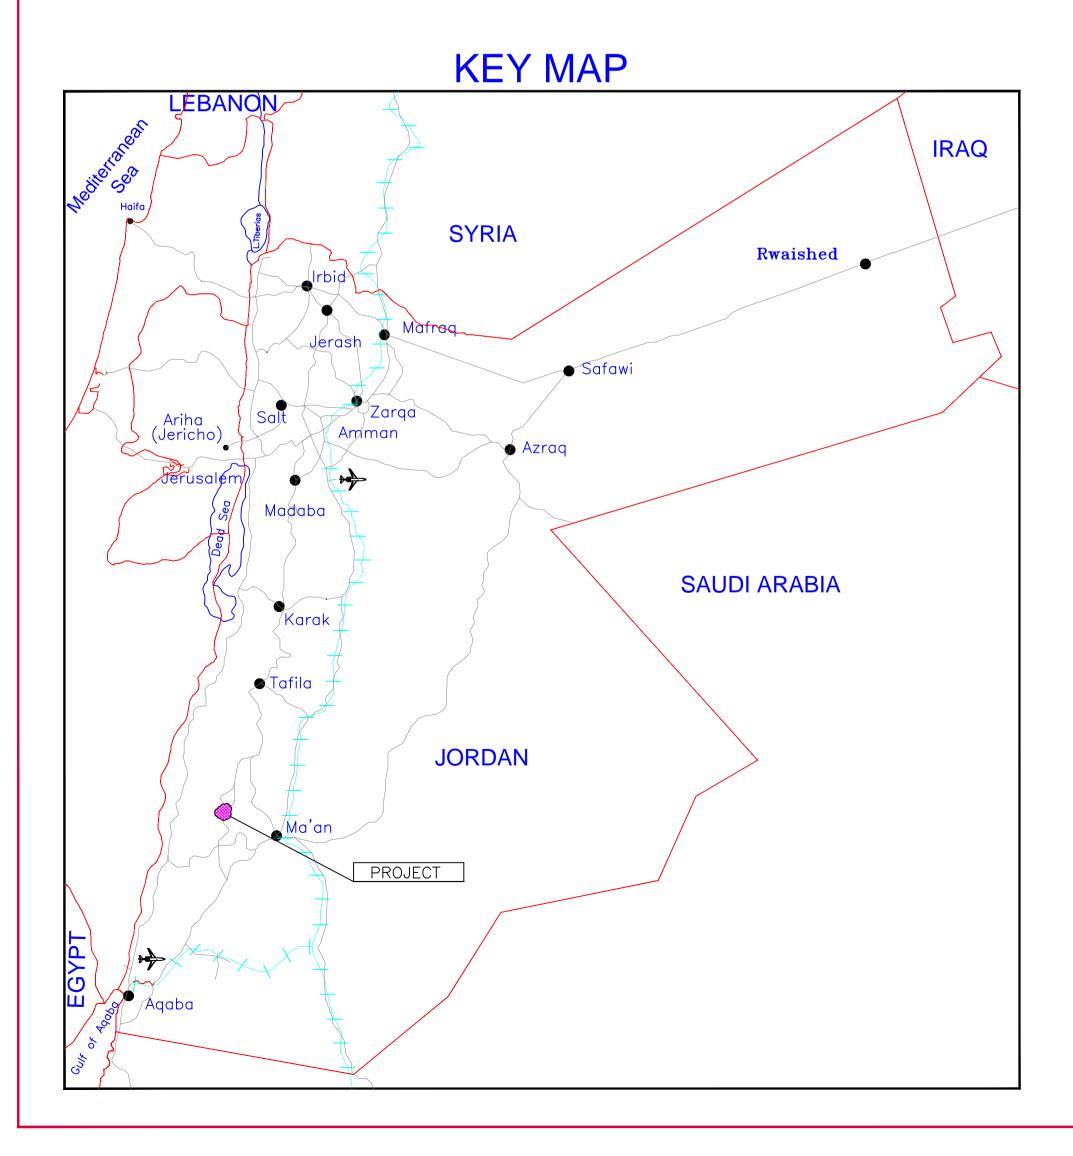





Amman – Jebel Amman – 29 Ibrahim Al Khaledi Street P.O. Box 942365 Amman – 11194 – Jordan Tel.: (9626) 56 81000 Fax: (9626) 56 90057 E-mail:infra@daralomran.com Web site: daralomran.com

GENERA	۹L	ELECTF AA-E-750
G-01 G-02	LIST OF DRAWINGS (1/2) LIST OF DRAWINGS (2/2)	AA-E-751 AA-E-752
	STRATION ANNEX	AA-E-752A AA-E-752B AA-E-753
AA-A-100 AA-A-101 AA-A-102 AA-A-103	GROUND FLOOR PLAN ROOF PLAN NOTATION PLAN TILING PLAN	AA-E-754 AA-E-755 CULTUR ARCHIT
AA-A-104 AA-A-105 AA-A-106 STRUC1 AA-S-250 AA-S-251 AA-S-252 AA-S-253	CEILING PLAN FURNITURE PLAN ELEVATION & SECTIONS FURAL GENERAL NOTES GENERAL DETAILS (1/2) GENERAL DETAILS (2/2) FOUNDATION LAYOUT	CC-A-100 CC-A-101 CC-A-102 CC-A-103 CC-A-104 CC-A-105 CC-A-106 CC-A-107
AA-S-254 AA-S-255 MECHA	BONDING BEAMS LAYOUT FRAMING PLAN	CC-A-108 CC-A-109
AA-M-500	GROUND FLOOR PLAN HVAC	STRUC1 CC-S-250
AA-M-501 AA-M-502 AA-M-503 AA-M-504 AA-M-505 AA-M-506 AA-M-507	EQUIPMENT SCHEDULE ROOF PLAN HVAC ROOF FLOOR HVAC DETAIL GROUND FLOOR PLAN WATER SUPPLY VIEW 1-1 WATER SUPPLY DETAILS GROUND FLOOR WATER SUPPLY DRAINAGE SYSTEM VIEW 1-1	CC-S-251 CC-S-252 CC-S-253 CC-S-254 CC-S-255 MECHA CC-M-500 CC-M-501
		CC-M-502

LIST OF DRAWINGS (1/2)

RICAL

- LIGHTING
- SOCKET
- FIRE ALARM
- IP ADDRESS SYSTEM
- CCTV SYSTEM **DISTRIBUTION BOARD 1/2 DISTRIBUTION BOARD 2/2** MAIN DISTRIBUTION BOARD

IRE AND EDUCATION CENTER

- TECTURAL
- GROUND FLOOR PLAN
- ROOF PLAN
- NOTATION PLAN
- TILING PLAN
- **CEILING PLAN**
- FURNITURE PLAN
- **ELEVATION B601**
- **SECTION B6A**
- SECTION B6B
- SECTION B6C

TURAL

- **GENERAL NOTES**
- GENERAL DETAILS (1/2)
- GENERAL DETAILS (2/2)
- FOUNDATION LAYOUT
- BONDING BEAMS LAYOUT
- FRAMING PLAN

ANICAL

- GROUND FLOOR PLAN HVAC GROUND FLOOR PLAN HVAC (1/2)
- GROUND FLOOR PLAN HVAC (2/2)

CC-M-503	EQUIPMENT SCHEDULE
CC-M-504	ROOF PLAN HVAC
CC-M-505	ROOF FLOOR HVAC DETA
CC-M-506	WATER SUPPLY
CC-M-507	WATER SUPPLY VIEW 1-1
CC-M-508	WATER SUPPLY DETAILS
CC-M-509	DRAINAGE SYSTEM GROUND FLOOR
CC-M-510	DRAINAGE SYSTEM VIEW
ELECTR	ICAL
CC-E-750	LIGHTING
CC-E-751	SOCKET

CC-E-752	FIRE ALARM
CC-E-752A	IP ADDRESS SYSTEM
CC-E-752B	CCTV SYSTEM
CC-E-753	DISTRIBUTION BOARD 1/2
CC-E-754	DISTRIBUTION BOARD 2/2
CC-E-755	MAIN DISTRIBUTION BOAI

INTERPRETATION CENTER ARCHITECTURAL

IC-A-100	GROUND FLOOR PLAN		
IC-A-101	ROOF PLAN		
IC-A-102	NOTATION PLAN		
IC-A-103	TILING PLAN		
IC-A-104	CEILING PLAN		
IC-A-105	FURNITURE PLAN		
IC-A-106	ELEVATION		
IC-A-107	SECTION B7A		
IC-A-108	SECTION B7B		
STRUCTURAL			
IC-S-250	GENERAL NOTES		
IC-S-251	GENERAL DETAILS (1/2)		
IC-S-252	GENERAL DETAILS (2/2)		
IC-S-253	FOUNDATION LAYOUT		

- IC-S-254 BONDING BEAMS LAYOUT
- IC-S-255 FRAMING PLAN

	D	
		NOTES :
TAIL		
-1		
S		
W 1-1		
/2		
2/2		BY DATE SUBJECT REV
ARD		Review/Verification Validation Stage II III IV A B CONSTRUCTION DOCUMENT
R		Date 0000-2012
		KEY PLAN
		NORTH
		CLIENT
		Petra Development & Tourism Region Autority Petra Development & Tourism Region Autority under Human (Human) Human (Human)
		HASHEMITE KINGDOM OF JORDAN PDTRA PETRA DEVELOPMENT TOURISM
		DAR AL-OMRAN Infrastructure and Environment
		P.O. Box 942365 Amman – 11194 – Jordan Tel.: (6626) 66 81000 Fax: (6626) 66 90057 E-mail:infra@daralomran.com Web site: daralomran.com PROJECT TITLE
		PETRA CULTURAL
		HERITAGE VILLAGE
		LIST OF DRAWINGS (1/2)
T		
		SCALE N.T.S WHEN PRINTED AT A1 SHEET SIZE DRAWN BY CHECKED BY APPROVED BY DESIGNED BY
		CAD&GIS SECTION H.D B.A M.SA D.M DATE PROJECT NO DRAWING NO REV
		MAY. 2015NLD76-12G-0100THIS DRAWING IS THE EXCLUSIVE PROPERTY OF DAR AL-OMRAN. REPRODUCTION IN ANY FORM WITHOUT THE WRITTEN CONSENT OF THE AFOREMENTIONED IS STRICTLY PROHIBITED.00
		OF THE AFOREMENTIONED IS STRICTLY PROHIBITED.

MECHANICAL

IC-M-500	GROUND FLOOR PLAN	IYPIC
	HVAC	TD-801
IC-M-501	EQUIPMENT SCHEDULE	TD-802
IC-M-502	ROOF PLAN HVAC	TD-803
IC-M-503	ROOF FLOOR HVAC DETAIL	TD-804
IC-M-504	GROUND FLOOR WATER SUPPLY	TD-805
IC-M-505	WATER SUPPLY VIEW 1-1	TD-806
IC-M-506	WATER SUPPLY DETAILS	TD-807
IC-M-507	GROUND FLOOR PLAN DRAINAGE SYSTEM	
IC-M-508	DRAINAGE SYSTEM VIEW 1-1	

ELECTRICAL

IC-E-750	LIGHTING
IC-E-751	SOCKET
IC-E-752	FIRE ALARM
IC-E-752A	IP ADDRESS SYSTEM
IC-E-752B	CCTV SYSTEM
IC-E-753	INSTRUMENT INSTALLATION
IC-E-754	DISTRIBUTION BOARD

DETAILS ARCHITECTURAL

IC-A-100	SKIRTING DETAILS
IC-A-101	FLOORING DETAILS
IC-A-102	THRESHOLD DETAILS & ROOF LAYER
IC-A-103	TYPICAL WALL SECTIONS (1/3)
IC-A-104	TYPICAL WALL SECTIONS (2/3)
IC-A-105 IC-A-106 IC-A-107 IC-A-108	TYPICAL WALL SECTIONS (3/3) CEILING DETAILS CEILING DETAILS FINISHING SCHEDULE
IC-A-109 IC-A-110 IC-A-111 IC-A-112 IC-A-113 IC-A-114 IC-A-115 IC-A-116 IC-A-117	WINDOW SCHEDULE NICHE SCHEDULE OPENING SCHEDULE DOOR SCHEDULE DOOR SCHEDULE DOOR DETAILS SIGNAGE DETAILS BATHROOM DETAILS
IC-A-118	BATHROOM DETAILS

LIST OF DRAWINGS (2/2)

TYPICAL DETAIL MECHANICAL

MECHANICAL 1/7 MECHANICAL 2/7 MECHANICAL 3/7 MECHANICAL 4/7 MECHANICAL 5/7 MECHANICAL 6/7 MECHANICAL 7/7

D	
	NOTES :
	BY DATE SUBJECT REV
	Review/Verification Validation Stage II III IV A B CONSTRUCTION DOCUMENT
	Date 0000-2012
	KEY PLAN
	NORTH
	CLIENT
	Petra Petra Petra Development & Tourism Region Authority همالطة (قليم البتسرا التتموي) المسياحس
	HASHEMITE KINGDOM OF JORDAN PDTRA PETRA DEVELOPMENT TOURISM
	DAR AL-OMRAN
	Amman – Jebel Amman – 29 Ibrahim Al Khaledi Street P.O. Box 942365 Amman – 11194 – Jordan Tel.: (9626) 56 81000 Fax: (9626) 56 90057 E-mail:infra@daralomran.com Web site: daralomran.com
	PROJECT TITLE
	PETRA CULTURAL HERITAGE VILLAGE
	DRAWING NAME
	LIST OF DRAWINGS (2/2)
	SCALE N.T.S WHEN PRINTED AT A1 SHEET SIZE
	DRAWN BY CHECKED BY APPROVED BY DESIGNED BY CAD&GIS M.SA D.M
	SECTIONH.DB.AH.DDATEPROJECT NODRAWING NOREVMAY. 2015NLD76-12C_0200
	THIS DRAWING IS THE EXCLUSIVE PROPERTY OF DAR AL-OMRAN. REPRODUCTION IN ANY FORM WITHOUT THE WRITTEN CONSENT
	OF THE AFOREMENTIONED IS STRICTLY PROHIBITED.